


# Addendum No. 5 Date: December 12, 2023

Project: Additions To Robertsdale High School For The Baldwin County Board of Education Robertsdale, Alabama

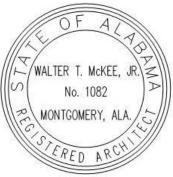

# MCKEE PROJECT NO. 23-195 ALABAMA DIVISION OF CONSTRUCTION MANAGEMENT NO. 2023533

The following changes and/or substitutions to the plans and specifications are hereby made a part of same and are incorporated in full force as part of the contract.

Bidders shall acknowledge receipt of this Addendum in writing on their Proposal Form.

## A5.1 GENERAL MODIFICATIONS:

A. None

# A5.2 SPECIFICATIONS MODIFICATIONS:

- A. The following manufacturers are hereby approved subject to the plans and specifications:
  - 1. Section 09811 Acoustical Sound Diffusers:
    - a. AVL Systems (Disorb Type W), Ocala, FL; Ph. 888-228-7842
    - b. Conwed; Maumee, OH; Ph. 419-871-9084
  - 2. Section 09843 Acoustical Wall Panels:
    - a. AVL Systems (Acoustech), Ocala, FL; Ph. 888-2287842
    - b. Conwed; Maumee, OH; Ph. 419-871-9084
  - 3. Section 16100 Electrical Lighting Fixtures:
    - a. Acuity Brands Lighting, <u>www.acuitybrands.com</u>
    - b. Lithonia Lighting, Conyers, GA
    - c. Brownlee Lighting, <u>www.brownlee.com</u>

#### A5.3 DRAWING MODIFICATIONS:


- A. See the attached Revised Drawings as follows:
  - 1. Sheet A8.1 (Revised 12-12-2023), herein.

## A5.4 CLARIFICATIONS & RESPONSES:


A. None

#### END OF ADDENDUM


| NO WORK REQUIRED    CMUP - CONCRETE MASONRY UNIT - PAINT    SC - SEALED CONCRETE    Pr - POLYMER FLOORING      GBP - ACOUSTICAL GYPSUM BOARD - PAINT    CMUP - CONCRETE MASONRY UNIT - NO PAINT    SC - SEALED CONCRETE    PF - POLYMER FLOORING      GBP - GYPSUM BOARD - PAINT    CMUP - METAL LINER WALL PANELS    Concrete    SC - SEALED CONCRETE  |  |
|---|--|
| AGBP - ACOUSTICAL GYPSUM BOARD - PAINT    CMU - CONCRETE MASONRY UNIT - NO PAINT    RSF - RUBBER SPORTS FLOORING (UNDER BID ALLOWANCE)    2    RB - RUBBER BASE      GBP - GYPSUM BOARD - PAINT    MLP - METAL LINER WALL PANELS    CMU - CONCRETE MASONRY UNIT - NO PAINT    RSF - RUBBER SPORTS FLOORING (UNDER BID ALLOWANCE)    2    RB - RUBBER BASE   | DOOR SCHEDULE  |
|   | DOOR #  WIDTH  HEIGHT  THICKNESS  MATERIALS  DOOR<br>TYPE  DOOR<br>FINISH  FRAME<br>TYPE  FRAME<br>FINISH  LABEL  DETAILS  SIGNAGE  REMARKS  |
| GB - GYPSUM BOARD - NO PAINT    PT - PORCELAIN TILE    2    C - CARPET      MGBP - MOISTURE RESISTANT GYPSUM BOARD - PAINT    RF - RESINOUS FLOORING    SFS - SYNTHETIC SPORTS FLOORING SYSTEM (SEE BID ALLOWANCE)    C - CARPET  | 800a    PAIR 3'-0"    7'-0"    1 3/4"    FIBERGLASS REINF.<br>PLASTIC    A    FACTORY    ASF1    FACTORY     15/A8.2    9/A8.2     INSULATED      800b    PAIR 3'-0"    7'-0"    1 3/4"    FIBERGLASS REINF.<br>PLASTIC    A    FACTORY    ASF1    FACTORY     15/A8.2    9/A8.2     INSULATED   |
| IGBP - IMPACT RESISTANT GYPSUM BOARD - PAINT WALLS CEILING  | BOUD  PAIR 3-0  7-0  13/4  PLASTIC  A  FACTORY  ASF1  FACTORY   15/A8.2  9/A8.2   INSULATED  |
| ROOM # ROOM NAME FLOOR BASE NORTH SOUTH EAST WEST TYPE HEIGHT WAINS. HEIGHT REMARKS   | 801      3'-0"      7'-0"      1 3/4"      FLUSH WOOD      D      FACTORY      HM1      PAINT       4/A8.2      5/A8.2      801 LADIES   |
| 800ENTRANCE LOBBYRFRCBCMUPCMUPCMUPSEE CEILING PLAN801LADIESRF2 (RCB)CMUPCMUPPTCMUPSEE CEILING PLAN  | 802    2'-8"    7'-0"    1 3/4"    FLUSH WOOD    D    FACTORY    HM1    PAINT     4/A8.2    5/A8.2    802 PIPE CHASE       803    3'-0"    7'-0"    1 3/4"    FLUSH WOOD    D    FACTORY    HM1    PAINT     4/A8.2    5/A8.2    802 PIPE CHASE  |
| 802  PIPE CHASE  SC   CMU  CMU  CMU  SEE CEILING PLAN    802  CENTS  DE  CONUD  CMUD  DE  CENTS   | 803    3'-0"    7'-0"    1 3/4"    FLUSH WOOD    D    FACTORY    HM1    PAINT     4/A8.2    5/A8.2    803 GENTLEMEN       804    3'-0"    7'-0"    1 3/4"    FLUSH WOOD    D    FACTORY    HM1    PAINT     4/A8.2    5/A8.2    803 GENTLEMEN  |
| 803    GENTS    RF    2 (RCB)    CMUP    CMUP    PT    SEE CEILING PLAN      804    JANITOR    RF    RCB    CMUP    CMUP    CMUP    SEE CEILING PLAN  | 804    3-0    7-0    1 3/4    FLUSH WOOD    D    FACTORY    HM1    PAINT     4/A8.2    5/A8.2    604 JANITORIAL       805    3'-8"    7'-0"    1 3/4"    FLUSH WOOD    D    FACTORY    HM1    PAINT     4/A8.2    5/A8.2    805 MECHANICAL   |
| 805  MECHANICAL  RF  RCB  CMUP<br>GBP  CMUP<br>GBP  CMUP<br>GBP  CMUP<br>GBP  CMUP<br>GBP  CMUP<br>GBP  CMUP<br>GBP  CMUP<br>GBP  CMUP<br>GBP  SEE CEILING PLAN    806  ELECTRICAL  RF  RCB  CMUP<br>GBP  CMUP<br>GBP  CMUP<br>GBP  CMUP<br>GBP  SEE CEILING PLAN   | 806      3'-4"      7'-0"      1 3/4"      FLUSH WOOD      D      FACTORY      HM1      PAINT       4/A8.2      5/A8.2      806 ELECTRICAL   |
| 807 CONCESSION RF RCB CMUP CMUP CMUP SEE CEILING PLAN   | 807a      3'-4"      7'-0"      1 3/4"      FLUSH WOOD      B      FACTORY      HM1      PAINT       4/A8.2      5/A8.2      807 CONCESSION  |
| 808  GYMNASIUM  SFS  2  SFS  CMUP  CMUP  CMUP  CMUP  MLP  MLP <t< td=""><td>807b  7'-0"  4'-3"   COUNTER SHUTTER  F  FACTORY  INTEGRAL  FACTORY   6/A8.2  7/A8.2   CONFIRM SHUTTER SIZE FOR 7' MASONRY OPENING</td></t<>  | 807b  7'-0"  4'-3"   COUNTER SHUTTER  F  FACTORY  INTEGRAL  FACTORY   6/A8.2  7/A8.2   CONFIRM SHUTTER SIZE FOR 7' MASONRY OPENING   |
| 810    CLOSET    RF    RCB    CMUP    CMUP    CMUP    SEE CEILING PLAN  | 808a      PAIR 3'-0"      7'-0"      1 3/4"      FLUSH WOOD      C      FACTORY      HM2      PAINT       4/A8.2      5/A8.2       IMPACT RESISTANT GLASS  |
| 810AVESTIBULERFRCBCMUPCMUPCMUPSEE CEILING PLAN810BHALLRFRCBCMUPCMUPCMUPSEE CEILING PLAN   | 808b      3'-0"      7'-0"      1 3/4"      FLUSH WOOD      C      FACTORY      HM2      PAINT       4/A8.2      5/A8.2       IMPACT RESISTANT GLASS   |
| 811    OFFICE    RF    RCB    CMUP    CMUP    CMUP    SEE CEILING PLAN      812    LAUNDRY    RF    RCB    CMUP    CMUP    CMUP    SEE CEILING PLAN   | 808c      3'-0"      7'-0"      1 3/4"      FLUSH WOOD      E      FACTORY      HM1      PAINT       4/A8.2      5/A8.2  |
| 812LAUNDRYRFRCBCMUPCMUPCMUPSEE CEILING PLAN813HALLRFRCBCMUPCMUPCMUPSEE CEILING PLAN   | 808d PAIR 3'-0" 7'-0" 1 3/4" FLUSH WOOD B FACTORY HM1 PAINT 4/A8.2 5/A8.2  |
| 814    GENTS DRESSING    RF    RCB    CMUP    CMUP    CMUP    SEE CEILING PLAN      814A    TOILET & SHOWER    RF    2    RCB    CMUP    PT    CMUP    PT    SEE CEILING PLAN   | 808e  PAIR 3'-4"  8'-0"  1 3/4"  FIBERGLASS REINF.<br>PLASTIC  E  FACTORY  AF2  FACTORY   8/A8.2  9/A8.2   INSULATED   |
| 815 LADIES DRESSING RF RCB CMUP CMUP CMUP SEE CEILING PLAN  | 808f PAIR 3'-0" 7'-0" 1 3/4" FLUSH WOOD B FACTORY HM1 PAINT 4/A8.2 5/A8.2  |
| 815A    TOILET & SHOWER    RF    2    RCB    PT    CMUP    PT    SEE CEILING PLAN      816    MECHANICAL    RF    RCB    CMUP    CMUP    CMUP    CMUP    GBP    GBP    GBP    SEE CEILING PLAN    E   | 809 3'-4" 7'-0" 1 3/4" FIBERGLASS REINF. D FACTORY AF1 FACTORY 8/A8.2 9/A8.2 809 SPRINKLER RISER INSULATED   |
| 817  TRAINING  RF  RCB  CMUP  CMUP  CMUP  SEE CEILING PLAN  | 810    3'-4"    7'-0"    1 3/4"    FLUSH WOOD    E    FACTORY    HM1    FACTORY     4/A8.2    5/A8.2    810 CLOSET   |
| 818OFFICERFRCBCMUPCMUPCMUPSEE CEILING PLAN819HALLRFRCBCMUPCMUPCMUPSEE CEILING PLAN  | 810A    3'-4"    7'-1" 2    1 3/4"    FIBERGLASS REINF.<br>PLASTIC    A    FACTORY    ASF2    FACTORY     8/A8.2    9/A8.2     INSULATED   |
| 820    JANITOR    RF    RCB    CMUP    CMUP    CMUP    SEE CEILING PLAN   | 811    3'-0"    1 3/4"    FLUSH WOOD    C    FACTORY    HM1    PAINT     4/A8.2    5/A8.2    811 OFFICE  |
| 822  GENERAL STORAGE  RF  RCB  CMUP  CMUP  CMUP  SEE CEILING PLAN   | 812    3'-4"    7'-0"    1 3/4"    FLUSH WOOD    C    FACTORY    HM1    PAINT     4/A8.2    5/A8.2    812 LAUNDRY  |
| 823    HALLWAY    RF    RCB    CMUP    CMUP    SEE CEILING PLAN      824    MECHANICAL    RF    RCB    CMUP    CMUP    CMUP    GBP    GBP    GBP    SEE CEILING PLAN    Image: Complex  | 814    3'-0"    1 3/4"    FLUSH WOOD    D    FACTORY    HM1    PAINT     4/A8.2    5/A8.2    814 GENTLEMEN DRESSING  |
| 825  HALL  RF  RCB  CMUP  CMUP  CMUP  SEE CEILING PLAN  | 815    3'-0"    7'-0"    1 3/4"    FLUSH WOOD    D    FACTORY    HM1    PAINT     4/A8.2    5/A8.2    815 LADIES DRESSING       010    014    7'-0"    1 3/4"    FLUSH WOOD    D    FACTORY    HM1    PAINT     4/A8.2    5/A8.2    815 LADIES DRESSING  |
| 826    STORAGE    RF    RCB    CMUP    CMUP    CMUP    SEE CEILING PLAN      827    LADIES DRESSING    RF    RCB    CMUP    CMUP    CMUP    SEE CEILING PLAN  | 816    3'-4"    7'-0"    1 3/4"    FLUSH WOOD    D    FACTORY    HM1    PAINT     4/A8.2    5/A8.2    816 MECHANICAL       917    2' 4"    7' 0"    1 3/4"    FLUSH WOOD    F    FACTORY    HM1    PAINT     4/A8.2    5/A8.2    816 MECHANICAL  |
| 827A TOILET & SHOWER RF (2)RCB CMUP CMUP PT CMUP SEE CEILING PLAN   | 817    3'-4"    7'-0"    1 3/4"    FLUSH WOOD    E    FACTORY    HM1    PAINT     4/A8.2    5/A8.2    817 TRAINING       818    3'-0"    7'-0"    1 3/4"    FLUSH WOOD    C    FACTORY    HM1    PAINT     4/A8.2    5/A8.2    817 TRAINING  |
| 828    OFFICE    RF    RCB    CMUP    CMUP    CMUP    SEE CEILING PLAN      829    OFFICE    RF    RCB    CMUP    CMUP    CMUP    SEE CEILING PLAN  | 810    3-0    7-0    1 3/4    FLUSH WOOD    C    FACTORY    HM1    PAINT     4/A8.2    5/A8.2    618 OFFICE       820    3'-0"    7'-0"    1 3/4"    FLUSH WOOD    D    FACTORY    HM1    PAINT     4/A8.2    5/A8.2    820 JANITORIAL   |
| 830    GENTS DRESSING    RF    RCB    CMUP    CMUP    CMUP    SEE CEILING PLAN      830A    TOILET & SHOWER    RF    2 (RCB)    CMUP    CMUP    PT    CMUP    SEE CEILING PLAN  | 821a    PAIR 3'-0"    7'-0"    1 3/4"    FLUSH WOOD    B    FACTORY    HM3    PAINT     4/A8.2    5/A8.2    821 PRACTICE FIELD   |
| 830A  TOILET & SHOWER  RF  2  RCB  CMUP  CMUP  PT  CMUP  SEE CEILING PLAN    831  ELECTRICAL & DATA  RF  RCB  CMUP  CMUP  CMUP  GBP  G  |  |
| B31  ELECTRICAL & DATA  RF  RCB  CMUP  CMUP  CMUP  CMUP  CMUP    832  HALL  RF  RCB  CMUP  CMUP  CMUP  SEE CEILING PLAN    840  VESTIBULE  RF  RCB  CMUP  CMUP  CMUP  SEE CEILING PLAN  |  |
| 841 SHEET MUSIC CLOSET RF RCB CMUP CMUP CMUP SEE CEILING PLAN   | 823  PAR 4-0  6-0  1 3/4  PLASTIC  PACTORY  PA  |
| 842  LADIES  RF  2  RCB  CMUP  PT  CMUP  SEE CEILING PLAN    843  JANITORS  RF  RCB  CMUP  CMUP  CMUP  SEE CEILING PLAN   | 826      3'-4"      7'-0"      1 3/4"      FLUSH WOOD      D      FACTORY      HM1      PAINT       4/A8.2      5/A8.2      826 STORAGE  |
| 844 GENTS RF 2 RCB CMUP PT CMUP SEE CEILING PLAN  | 827      3'-0"      7'-0"      1 3/4"      FLUSH WOOD      D      FACTORY      HM1      PAINT       4/A8.2      5/A8.2      827 LADIES LOCKER ROOM   |
| 845    BAND DIRECTOR    RF    RCB    CMUP    CMUP    CMUP    SEE CEILING PLAN      845A    TOILET & SHOWER    RF    2    RCB    PT    CMUP    CMUP    SEE CEILING PLAN       946    ENGEMBLE DELIEAD CAL    N/T    CMUP   | 828      3'-0"      7'-0"      1 3/4"      FLUSH WOOD      D      FACTORY      HM1      PAINT       4/A8.2      5/A8.2      828 OFFICE   |
| 846  ENSEINBLE REHEARSAL  LV1  R  AGBP  AGB   | 829      3'-0"      7'-0"      1 3/4"      FLUSH WOOD      1      D      FACTORY      HM1      PAINT       4/A8.2      5/A8.2      829 OFFICE  |
| 847    ASSISTANT DIRECTORS    LVT    R    CMUP    CMUP    CMUP    SEE CEILING PLAN      848    BAND ROOM    LVT    R    CMUP    CMUP    CMUP    CMUP    SEE CEILING PLAN    ** HIGH NRC LAY-IN CEILING  | 830    3'-0"    7'-0"    1 3/4"    FLUSH WOOD    D    FACTORY    HM1    PAINT     4/A8.2    5/A8.2    830 GENTS LOCKER ROOM  |
| 849    UNIFORMS STORAGE    RF    RCB    CMUP    CMUP    CMUP    SEE CEILING PLAN      850    HALLWAY    RF    RCB    CMUP    CMUP    CMUP    SEE CEILING PLAN   | 831    3'-4"    7'-0"    1 3/4"    FLUSH WOOD    D    FACTORY    HM1    PAINT     4/A8.2    5/A8.2    831 ELECTRICAL & DATA  |
| 851 PERCUSSION STORAGE RF RCB CMUP CMUP CMUP SEE CEILING PLAN   | 840a  PAIR 3'-0"  7'-0"  1 3/4"  FIBERGLASS REINF.<br>PLASTIC  A  FACTORY  AF2  PACTORY   13/A8.2  9/A8.2  |
| 852  MECHANICAL  SC   CMUP<br>GBP  CMUP<br>GBP  CMUP<br>GBP  CMUP<br>GBP  SEE CEILING PLAN    853  LOADING VESTIBULE  RF  RCB  CMUP  CMUP  CMUP  SEE CEILING PLAN   | 840b      PAIR 3'-0"      7'-0"      1 3/4"      FLUSH WOOD      C      FACTORY      HM4      PAINT       BRACE TO<br>STRUCTURE      5/A8.2<br>SIMILAR   |
| 854 UTILITY RF RCB CMUP CMUP CMUP SEE CEILING PLAN  | 841      3'-0"      7'-0"      1 3/4"      FLUSH WOOD      B      FACTORY      HM1      PAINT       4/A8.2      5/A8.2      841 MUSIC CLOSET   |
| 855  MECHANICAL  SC   CMUP<br>GBP  <  | 842    3'-0"    1 3/4"    FLUSH WOOD    D    FACTORY    HM1    PAINT     4/A8.2    5/A8.2    842 LADIES  |
| SEE SCHED   | 843    3'-4"    7'-0"    1 3/4"    FLUSH WOOD    D    FACTORY    HM1    PAINT     4/A8.2    5/A8.2    843 JANITORIAL   |
| SEE SCHED SEE SCHED SEE SCHED SEE SCHED SEE SCHED SEE SCHED   | 844    3'-0"    7'-0"    1 3/4"    FLUSH WOOD    D    FACTORY    HM1    PAINT     4/A8.2    5/A8.2    844 GENTLEMEN  |
|   | 845    3'-0"    7'-0"    1 3/4"    FLUSH WOOD    C    FACTORY    HM1    PAINT     4/A8.2    5/A8.2    845 BAND DIRECTOR  |
|   | 845a      3'-0"      7'-0"      1 3/4"      FLUSH WOOD      D      FACTORY      HM1      PAINT       4/A8.2      5/A8.2      845A SHOWER   |
|   | 845b    3'-0"    7'-0"    1 3/4"    FLUSH WOOD    D    FACTORY    HM1    PAINT     4/A8.2    5/A8.2    845A SHOWER       846    3'-0"    7'-0"    1 3/4"    FIBERGLASS REINF.<br>PLASTIC    D    FACTORY    AF1    PAINT     8/A8.2    9/A8.2     INSULATED  |
|   | 040 3-0 7-0 13/4 PLASTIC D FACTORT 0/A6.2 9/A6.2 INSULATED   |
| B  A  A  A  A  A  A    B  A  B  A  A  A  A    B  A  B  A  B  A  A   | 847b      3'-0"      7'-0"      1 3/4"      FLUSH WOOD      C      FACTORY      HM1      FACTORY       4/A8.2      5/A8.2  |
|   |  |
| TYPE "A" TYPE "B" TYPE "C" TYPE "D" TYPE "E" TYPE "F" TYPE "G"  | 848a  PAIR 3-0  7-0  1 3/4  METAL DOOR  2  E  PAINT   4/A8.2  5/A8.2  848 BAND REHEARSAL  50 STC WITH SOUND STRIPS & D    848b  PAIR 3'-0"  7'-0"  1 3/4"  FIBERGLASS REINF.<br>PLASTIC  E  FACTORY  AF2  FACTORY   13/A8.2  9/A8.2   INSULATED  |
| TIG NOTE: PANIC EXIT DEVICE MUST NOT OBSCURE<br>THE BOTTOM OF THE VISION LIGHT  | 849      PAIR 3'-0"      7'-0"      1 3/4"      FLUSH WOOD      B      FACTORY      HM1      PAINT       4/A8.2      5/A8.2      849 STORAGE   |
| CTI AT DOORS  CT  CT    808a & 808b  CT  CT   | 850a      4'-0"      7'-0"      1 3/4"      FLUSH WOOD      B      FACTORY      HM1      PAINT       4/A8.2      5/A8.2      850 HALLWAY   |
| DOOR TYPES  | 850b      4'-0"      7'-0"      1 3/4"      FLUSH WOOD      B      FACTORY      HM1      PAINT       4/A8.2      5/A8.2  |
| SCALE: 1/4" - 1'-0"   | No.   |
| 2" SEE SCHED 2" 2" SEE SCHED 6" SEE SCHED 2" 2" SEE SCHED 2" 2-1/2" 6'-0" 2-1/2" 5'-3 1/4" FRAME 2" SEE 2" 2" SEE 2" 2" SEE SCHED 2" SE  | 2" { 852 PAIR 3'-0" 7'-0" 1 3/4" FIBERGLASS REINF. PLASTIC D FACTORY AF2 FACTORY 8/A8.2 9/A8.2 852 MECHANICAL INSULATED  |
| $2 \frac{1}{2}$ $2 \frac{1}{2}$ SEE $\frac{21}{2}$ $2 \frac{1}{2}$ SCHEDULE   | 853a      8'-0"      7'-4"       COILING DOOR      G      PAINT      INTEGRAL      PAINT       11/A8.2      12/A8.2       INSULATED  |
|   | 853b PAIR 3'-6" 7'-0" 1 3/4" FLUSH WOOD E FACTORY HM1 PAINT 4/A8.2 5/A8.2 853 LOADING VESTIBULE  |
|   | 854  4'-0"  7'-0"  2  1 3/4"  FIBERGLASS REINF.<br>PLASTIC  D  FACTORY  AF1  2  FACTORY   8/A8.2  9/A8.2  854 UTILITY  INSULATED   |
|   | 854a    3'-0"    7'-0"    1 3/4"    FLUSH WOOD    E    FACTORY    HM1    PAINT     4/A8.2    5/A8.2    854 UTILITY   |
|   | 855  PAIR 3'-0"  7'-0"  1 3/4"  FIBERGLASS REINF.<br>PLASTIC  D  FACTORY  FACTORY   4/A8.2  5/A8.2  855 MECHANICAL  INSULATED  |
|   |  |
| SEE SCHED   | 856 PAIR 3'-0" 7'-0" 2 1 3/4" FIBERGLASS REINF. D FACTORY AF2 FACTORY 8/A8.2 9/A8.2 856 MECHANICAL INSULATED   |
| HM1 HM2 SO CORRIDOR WIDTH HM3 KASE1 ASE1 ASE2 AF1 AF2   | Comparison  Comparison |
| HM1 HM2<br>B'-O' CORRIDOR WIDTH HM3<br>B'-O' CORRIDOR WIDTH EQ.<br>HM3 HM3 HM3 HM3 HM3 HM3 HM3 HM3 HM3 HM3  | $\left\{ \begin{array}{c c c c c c c c c c c c c c c c c c c $   |
| HM1 HM2<br>FRAME TYPES<br>CALE: 144"-11-0"  | $\left\{ \begin{array}{c c c c c c c c c c c c c c c c c c c $   |
| HM1 HM2<br>FRAME TYPES  | $ \begin{array}{c ccccccccccccccccccccccccccccccccccc$   |
| HM1<br>HM2<br>FRAME TYPES<br>CALE: 1/4' - 1'-0'<br>HM3<br>CALE: 1/4' - 1'-0'<br>HM4<br>HM3<br>CALE: 1/4' - 1'-0'<br>HM3<br>HM3<br>HM3<br>HM3<br>CALE: 1/4' - 1'-0'<br>HM3<br>HM3<br>CALE: 1/4' - 1'-0'<br>HM3<br>HM3<br>CALE: 1/4' - 1'-0'<br>HM3<br>HM3<br>CALE: 1/4' - 1'-0'<br>HM3<br>HM3<br>CALE: 1/4' - 1'-0'<br>HM3<br>CALE: 1/4' - 1'-0'<br>HM3<br>CALE: 1/4' - 1'-0'<br>HM3<br>CALE: 1/4' - 1'-0'<br>HM3<br>CALE: 1/4' - 1'-0'<br>CALE: 1/4' - 1'-0' | $ \begin{array}{c c c c c c c c c c c c c c c c c c c $  |
| HM1 HM2<br>FRAME TYPES<br>CALE: 1/4*- 1*-0*<br>HM3 HASF = ALLUMINUM TUBE FRAME BY FRP DOOR MANUF.<br>HM3 HASF = ALLUMINUM TUBE FRAME BY FRP DOOR MANUF.<br>HM3 HASF = ALLUMINUM TUBE FRAME BY FRP DOOR MANUF.<br>HM3 HASF = ALLUMINUM TUBE FRAME BY FRP DOOR MANUF.<br>HM3 HASF = ALLUMINUM TUBE FRAME BY FRP DOOR MANUF.<br>HM3 HASF = ALLUMINUM TUBE FRAME BY FRP DOOR MANUF.<br>HM3 HASF = ALLUMINUM TUBE FRAME BY FRP DOOR MANUF.<br>HM3 HASF = ALLUMINUM TUBE FRAME BY FRP DOOR MANUF.<br>HM3 HASF = ALLUMINUM TUBE FRAME BY FRP DOOR MANUF.<br>HM3 HASF = ALLUMINUM TUBE FRAME BY FRP DOOR MANUF.<br>HM3 HASF = ALLUMINUM TUBE FRAME BY FRP DOOR MANUF.<br>HM3 HASF = ALLUMINUM TUBE FRAME BY FRP DOOR MANUF.<br>HM3 HASF = ALLUMINUM TUBE FRAME BY FRP DOOR MANUF.<br>HM3 HASF = ALLUMINUM TUBE FRAME BY FRP DOOR MANUF.<br>HM3 HASF = ALLUMINUM TUBE FRAME BY FRP DOOR MANUF.<br>HM3 HASF = ALLUMINUM TUBE FRAME BY FRP DOOR MANUF.<br>HM3 HASF = ALLUMINUM TUBE FRAME BY FRP DOOR MANUF.<br>HM3 HASF = ALLUMINUM TUBE FRAME BY FRP DOOR MANUF.<br>HM3 HASF = ALLUMINUM TUBE FRAME BY FRP DOOR MANUF.<br>HM4 HASF = ALLUMINUM TUBE FRAME BY FRP DOOR MANUF.<br>HM4 HASF = ALLUMINUM TUBE FRAME BY FRP DOOR MANUF.<br>HM4 HASF = ALLUMINUM TUBE FRAME BY FRP DOOR MANUF.<br>HM4 HASF = ALLUMINUM TUBE FRAME BY FRP DOOR MANUF.<br>HM4 HASF = ALLUMINUM TUBE FRAME BY FRP DOOR MANUF.<br>HM4 HASF = ALLUMINUM TUBE FRAME BY FRP DOOR MANUF.<br>HM4 HASF = ALLUMINUM TUBE FRAME BY FRP DOOR MANUF.<br>HM4 HASF = ALLUMINUM TUBE FRAME BY FRP DOOR MANUF.<br>HM4 HASF = ALLUMINUM TUBE FRAME BY FRP DOOR MANUF.<br>HM4 HASF = ALLUMINUM TUBE FRAME BY FRP DOOR MANUF.<br>HM4 HASF = ALLUMINUM TUBE FRAME BY FRP DOOR MANUF.<br>HM4 HASF = ALLUMINUM TUBE FRAME BY FRP DOOR MANUF.<br>HM4 HASF = ALLUMINUM TUBE FRAME BY FRP DOOR MANUF.<br>HM4 HASF = ALLUMINUM TUBE FRAME BY FRP DOOR MANUF.<br>HM4 HASF = ALLUMINUM TUBE FRAME BY FRP DOOR MANUF.<br>HM4 HASF = ALLUMINUM TUBE FRAME BY FRP DOOR MANUF.<br>HM4 HASF = ALLUMINUM TUBE FRAME BY FRP DOOR MANUF.<br>HM4 HASF = ALLUMINUM TUBE FRAME BY FRP DOOR MANUF.<br>HM4 HASF = ALLUMINUM TUBE FRAME BY FRP DOOR MANUF.<br>HM4 HASF = ALLUMINUM TUBE FRA  | $\left\{\begin{array}{c c c c c c c c c c c c c c c c c c c $  |
| HM1 HM2<br>FRAME TYPES<br>CALE: 1/4"- 1"-0"<br>HM2<br>HM2<br>HM2<br>HM3<br>HM3<br>HM3<br>HM3<br>HM3<br>HM3<br>HM3<br>HM3  | $\begin{array}{c c c c c c c c c c c c c c c c c c c $   |
| HM1<br>HM2<br>HM2<br>HM2<br>HM2<br>HM2<br>HM2<br>HM2<br>HM2<br>HM2<br>HM2   | $\frac{1}{2}$  |

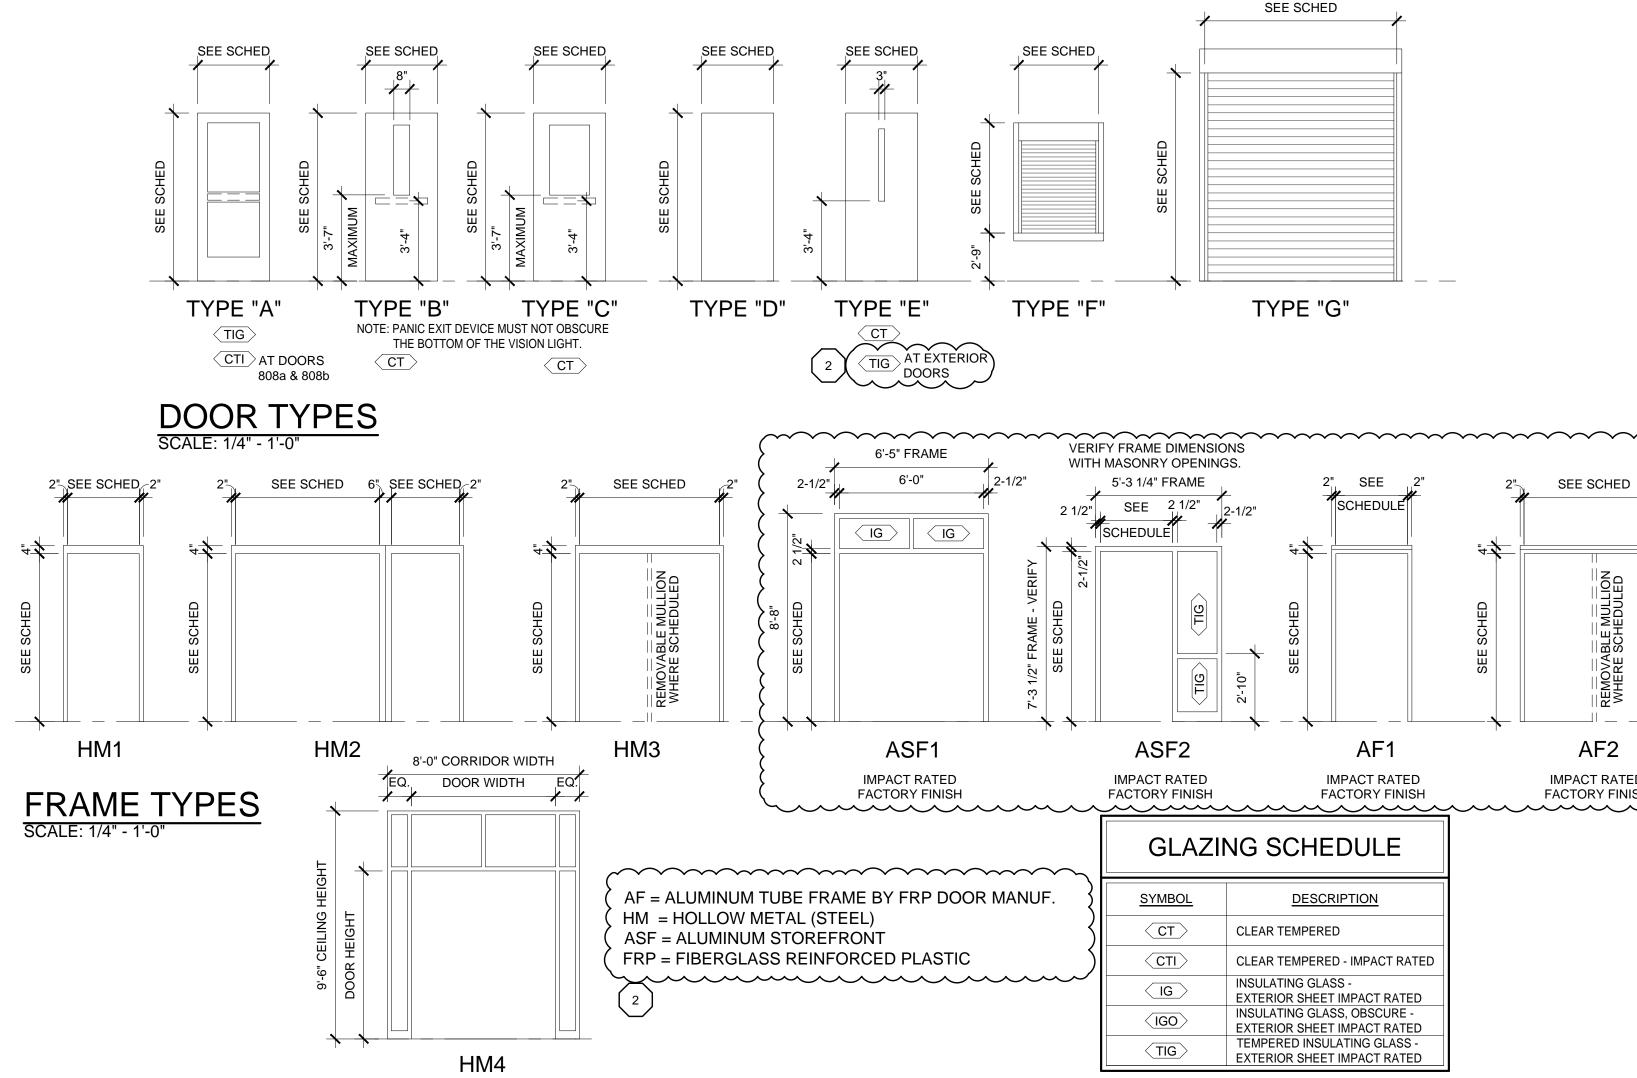

- Z:\2023\23-195 Additions to Robertsdale High Sch - Tuesday, December 12, 2023 12:44:43 PM

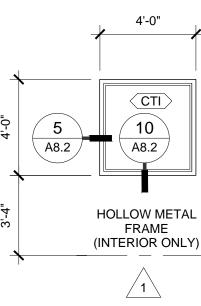

# SCALE: 1/4" - 1'-0"

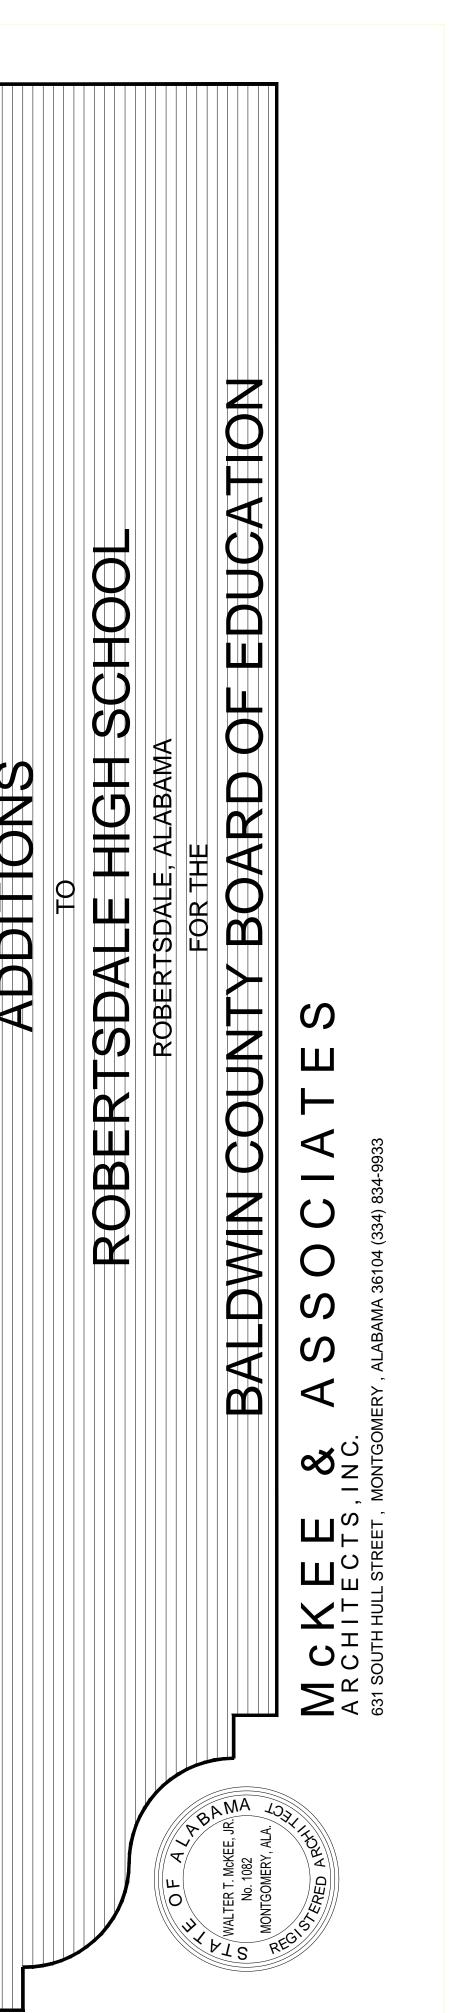

SHEET TITLE :

MCKEE JOB # : 23-195

DRAWN BY : DATE:

FINISH SCHEDULE, DOOR SCHEDULE, WINDOW SCHEDULE

JL, VH 10-11-2023 REVISED DATE: 1 11-17-2023 REVISED DATE: 2 12-8-2023 REVISED DATE: 3 12-12-2023

SHEET NO.: A8.1